




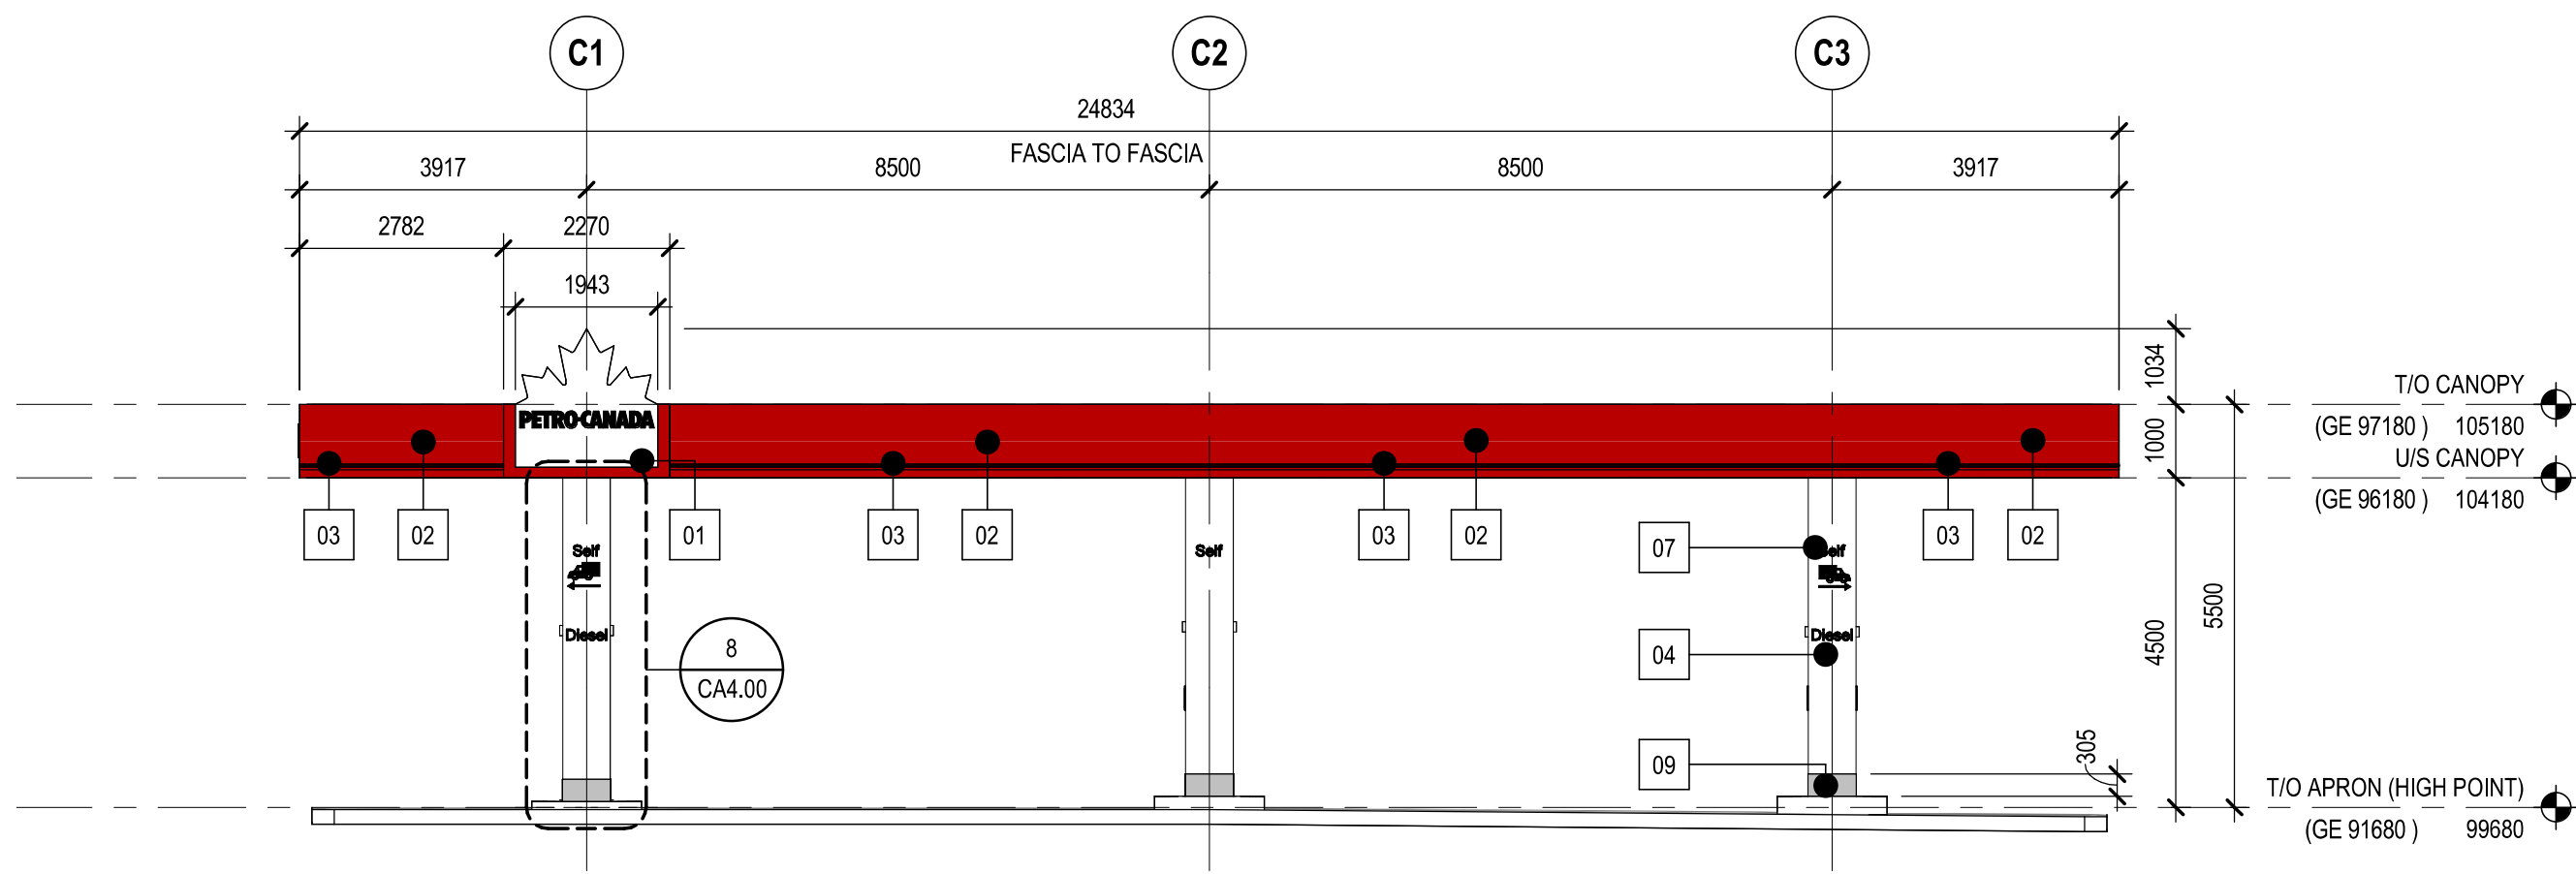


1 EAST ELEVATION
CA4.00 SCALE: 1 : 100

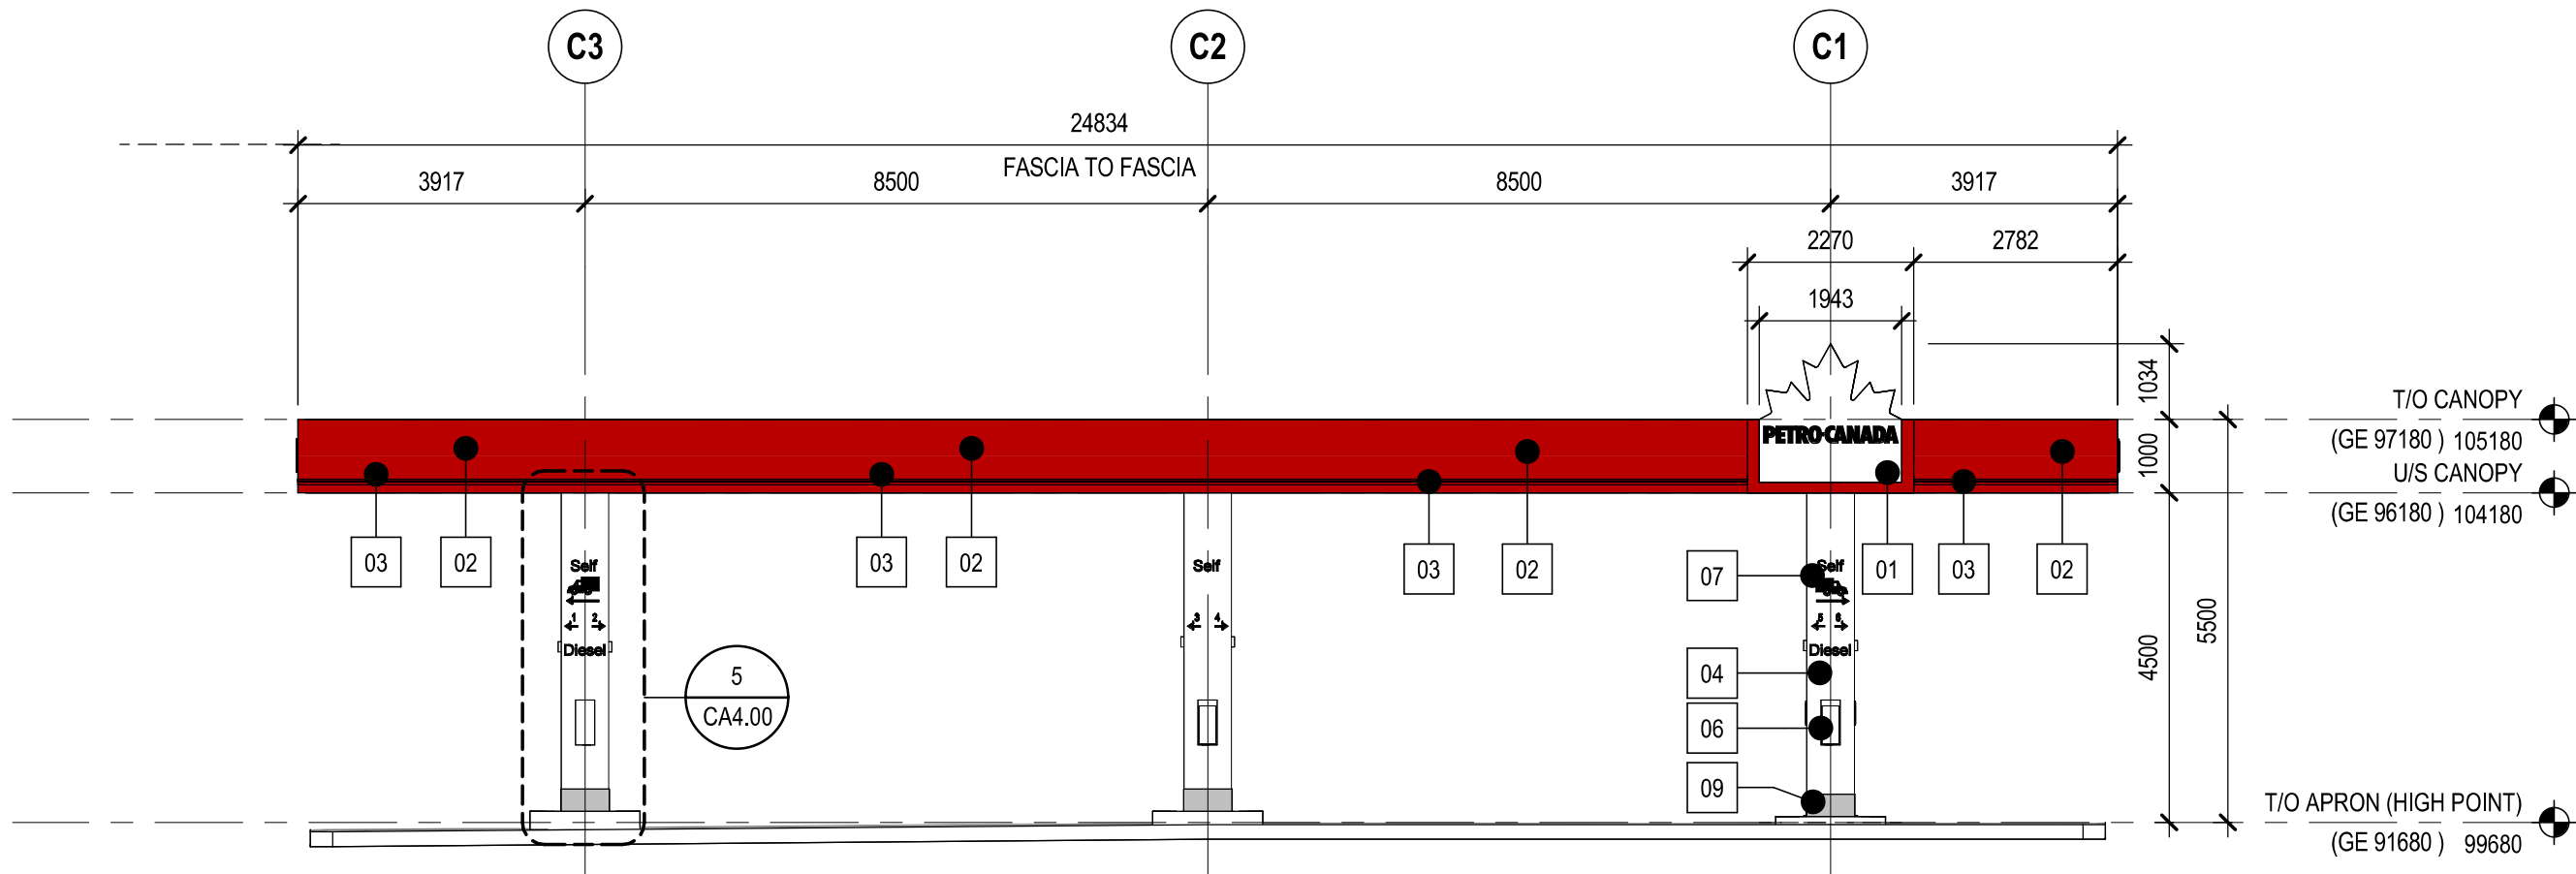

3 WEST ELEVATION
CA4.00 SCALE: 1 : 100

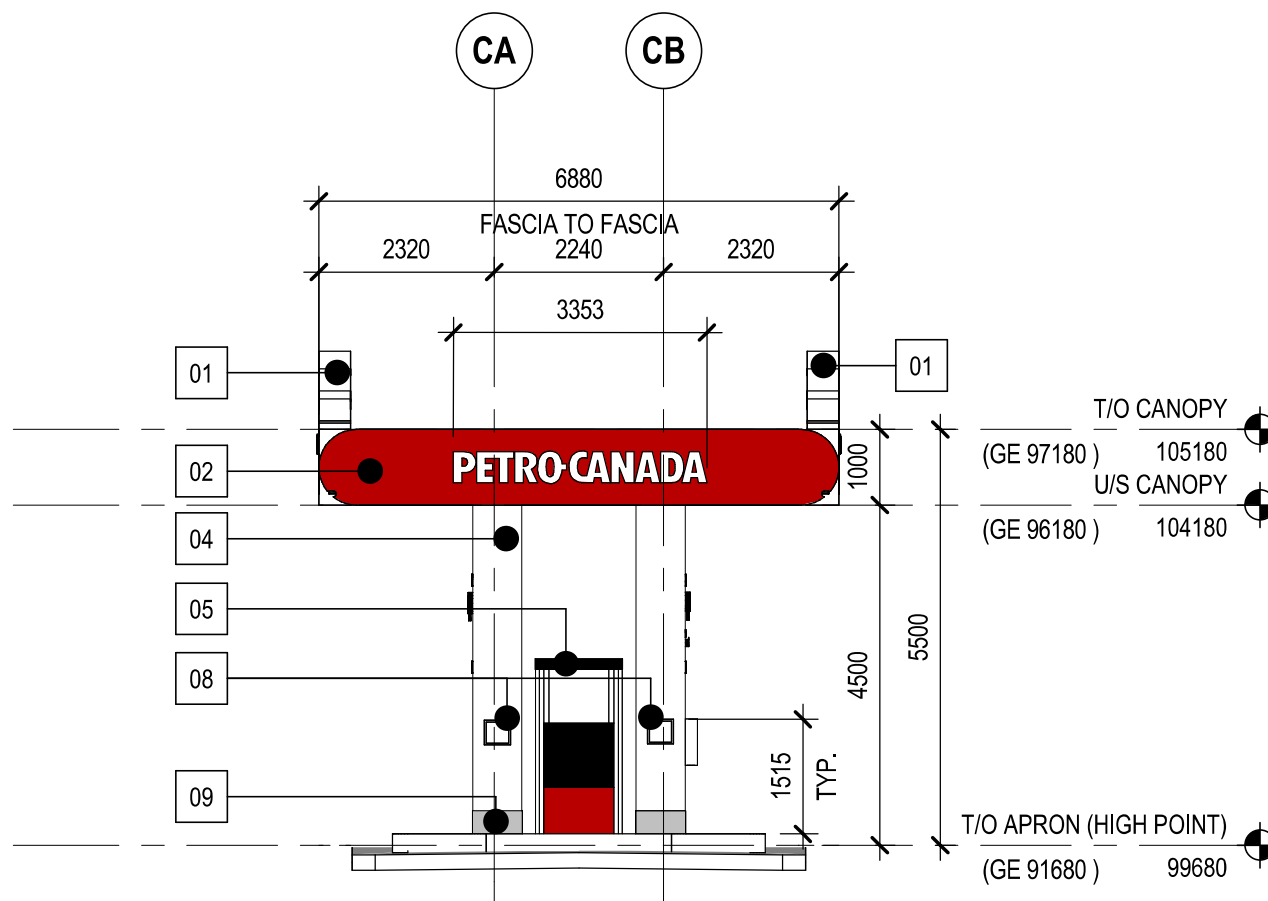

2 NORTH ELEVATION
CA4.00 SCALE: 1 : 100

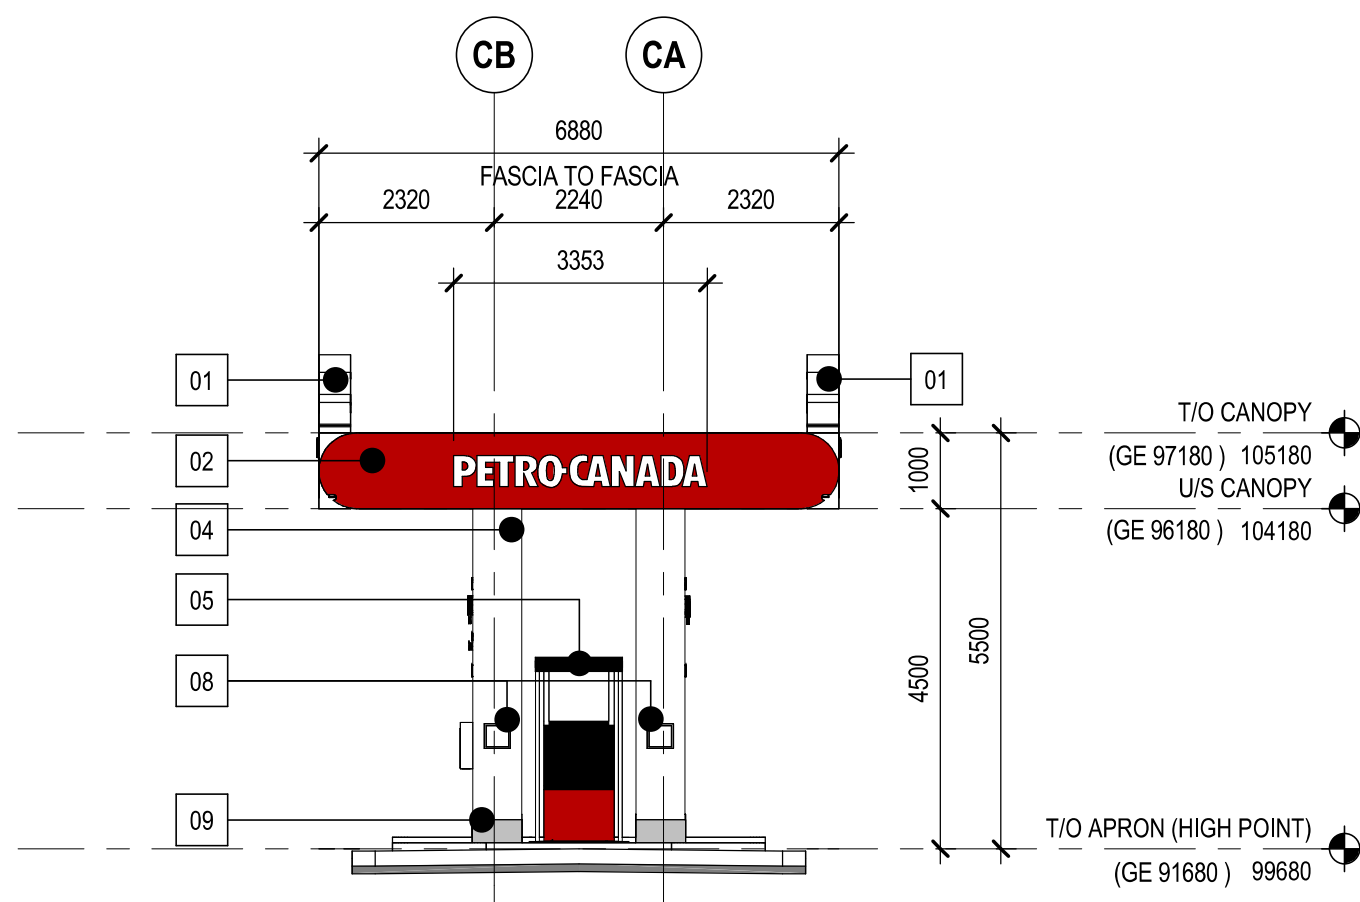


4 SOUTH ELEVATION
CA4.00 SCALE: 1 : 100

KEYNOTE LEGEND	
NUMBER	DESCRIPTION
01	ROUND PROFILE ALUMINUM COMPOSITE METAL CLADDING WITH LED RECESS. COLOUR RED PANTONE 186
02	ALUMINUM COMPOSITE METAL CLADDING. COLOUR RED PANTONE 186
03	RECESSED LED STRIP G.E. CONTOUR LED. COLOUR RED
04	INTERNALLY ILLUMINATED SIGNAGE. TRANSLUSCENT WHITE FACE AND BLACK TEXT
05	INTERNALLY ILLUMINATED SIGNAGE. WHITE PUSH THRU LETTERS 25mm THICK
06	ALLUMINUM COMPOSITE METAL PANEL. COLOUR WHITE. SEE NOTES BELOW
07	FUEL DISPENSER UNIT
08	FIRE EXTINGUISHER. ONE PER COLUMN
09	VINYL LETTER/GRAPHIC (COLOUR: BLACK)

GENERAL NOTES

- WHITE COMPOSITE PANEL ACCEPTABLE PRODUCTS.
A. ALUCOBOND, COLOUR "PC COOL WHITE"
B. ALPOLIC, COLOUR "SAW WHITE"
C. REYNOBOND, COLOUR "PROGRAM WHITE"
- ALL SIGNAGE TO BE REVIEWED UNDER A SEPARATE SIGN PERMIT APPLICATION

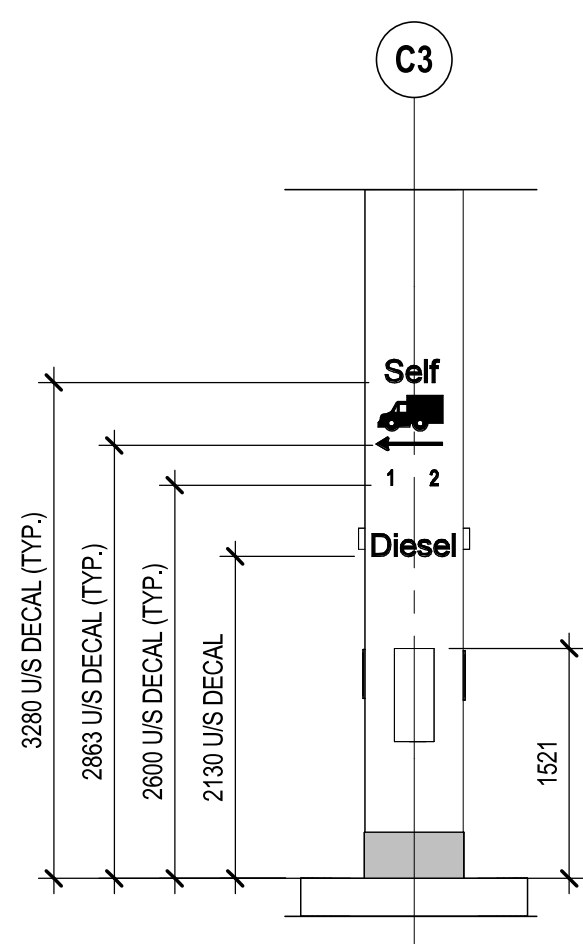


5 WEST ELEVATION - DECAL
CA4.00 SCALE: 1 : 50



REVISION TABLE		
REV.	DESCRIPTION	DRAWN / APP'D DATE

ISSUE TABLE		
1	DEVELOPER COORDINATION	2025-10-10
2	BUILDING PERMIT CLIENT REVIEW	2026-02-11
3	BUILDING PERMIT	2026-02-25
4	BID	2026-03-25
5	DEVELOPMENT PERMIT (CANOPY ONLY)	2026-06-19

METRIC
THIS DRAWING IS COPYRIGHTED AND MUST NOT BE USED, REPRODUCED, OR REVISED WITHOUT WRITTEN PERMISSION. ALL DIMENSIONS ARE IN MILLIMETERS UNLESS OTHERWISE NOTED. VERIFY DIMENSIONS DO NOT SCALE THIS DRAWING. REPORT INCONSISTENCIES AND OMISSIONS TO THE CONSULTANT FOR CLARIFICATION BEFORE COMMENCING WITH THE WORK. DEVIATIONS FROM THE CONTRACT DOCUMENTS WITHOUT WRITTEN APPROVAL FROM THE CONSULTANT ARE SUBJECT TO CORRECTION AT THE CONTRACTOR'S EXPENSE.

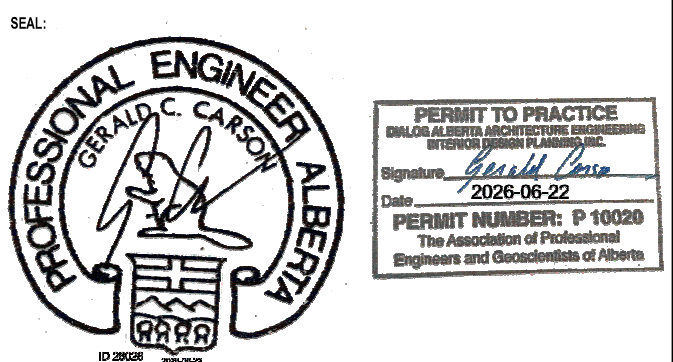

CONSULTANT:
DIALOG
300 - 134 11 AVENUE SE
CALGARY, AB
T2G 0X5
Tel: 403-245-5501



DRAWING TITLE:
EXTERIOR ELEVATIONS & BUILDING SECTIONS

PROJECT:
PETRO-CANADA LEWISTON

#400 1100 140 AVENUE NE
CALGARY, AB

DRAWN: GA	SHEET SIZE: ANSI D 594mm x 841mm
DRAWN SCALE: As indicated	PETRO-CANADA FILE No.
DATE DRAWN: 2026-06-19	CONSULTANT FILE No.
CHECKED BY: KR	PLOT SCALE
APPROVED BY: Approver	PLOT DATE: 6/19/2026 11:58:12 AM
AB100728-2009463	PLOT CONFIGURATION
STD No./ OUTLET No. 29560	CA4.00