


1. TANKAGE AREA SHALL BE PROTECTED FROM PUBLIC ACCESS. IF PUBLIC ACCESS CANNOT BE PREVENTED WITHIN THIS AREA, IT IS RECOMMENDED THAT TANK LIDS BE REINFORCED, LOCKABLE AND WATERTIGHT.
2. CONTROL PANEL SHALL BE INSTALLED WITHIN A LOCKABLE, TAMPER PROOF BOX.
3. PROPOSED SEWAGE SYSTEM SHALL BE GRASS COVERED ONLY.
4. PROPOSED LEACHING BED AREA SHALL BE PROTECTED FROM VEHICULAR TRAFFIC WITH BOLLAARDS OR CONCRETE CURBING.
5. TREES WITHIN 5m OF DISTRIBUTION PIPES TO BE REMOVED/RELOCATED OR, A ROOT BARRIER SHALL BE INSTALLED VERTICALLY ALONG THE EXCAVATION OF THE PROPOSED SEWAGE SYSTEM FROM THE BASE OF THE SYSTEM EXTENDING TO THE FINISHED GRADE.
6. SNOW STORAGE SHALL NOT BE LOCATED OVER PROPOSED SEWAGE SYSTEM.
7. IT IS RECOMMENDED THAT THE LEACHING BED AREA BE SODDED AS SOON AS POSSIBLE.
8. SURFICIAL DRAINAGE SHALL BE DIRECTED AWAY FROM THE PROPOSED SEWAGE SYSTEM.

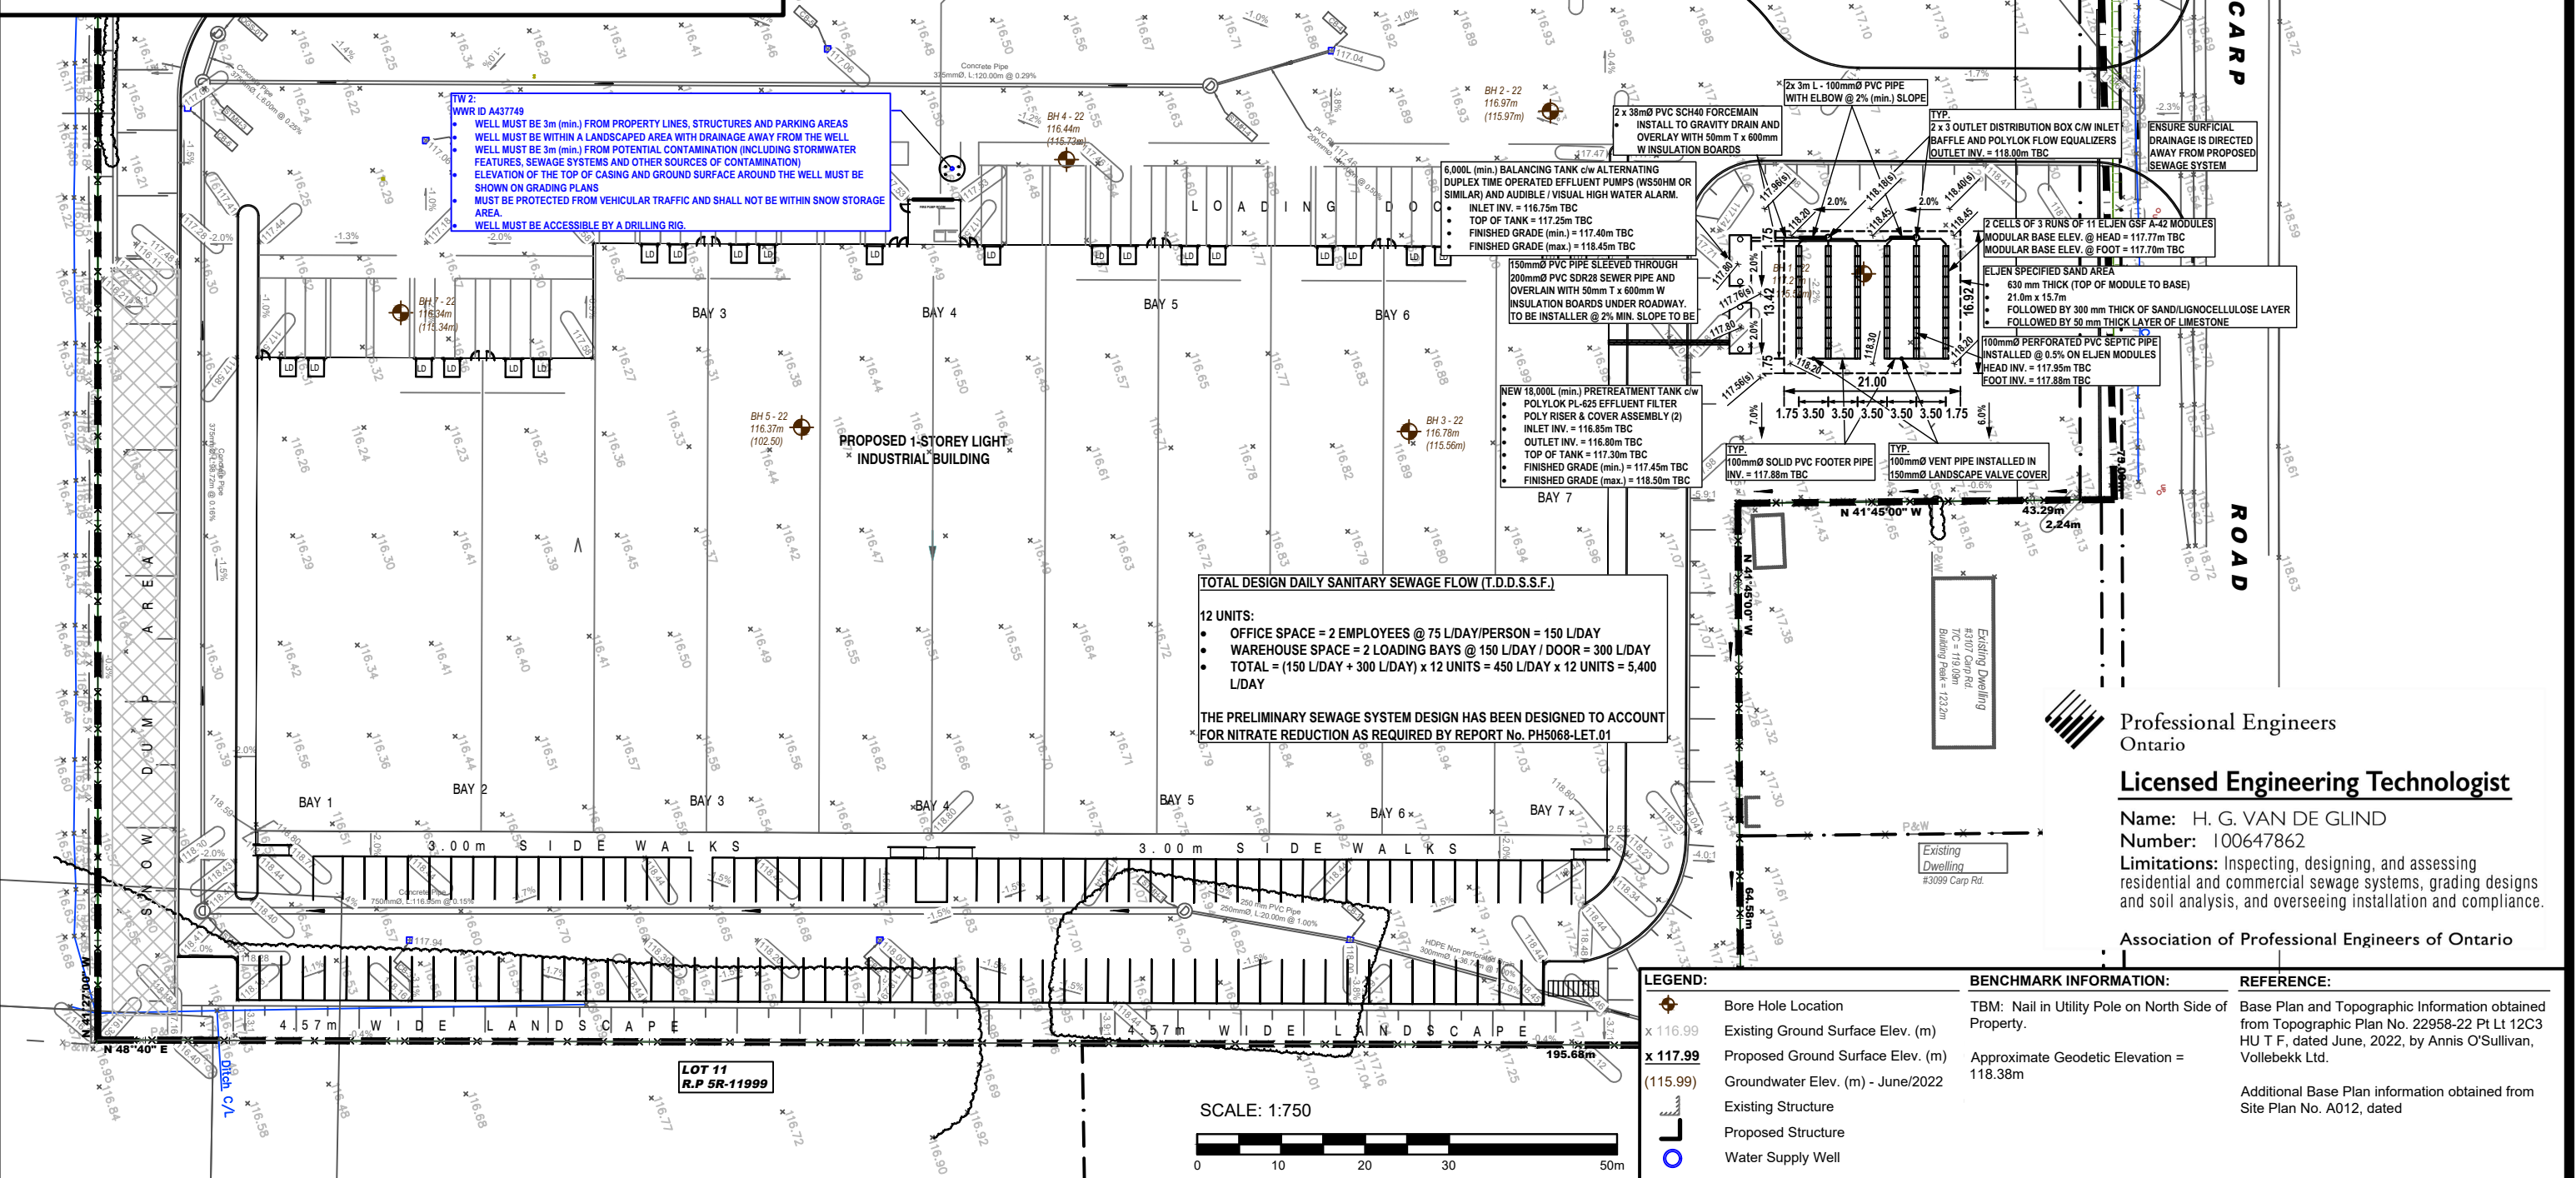

Professional Engineers
Ontario

Licensed Engineering Technologist

Name: H. G. VAN DE GLIND
Number: 100647862
Limitations: Inspecting, designing, and assessing residential and commercial sewage systems, grading designs and soil analysis, and overseeing installation and compliance.

Association of Professional Engineers of Ontario

LEGEND:

- | | |
|---|-----------------------------------|
|  | Bore Hole Location |
|  | Existing Ground Surface Elev. (m) |
|  | Proposed Ground Surface Elev. (m) |
|  | Groundwater Elev. (m) - June/2022 |
|  | Existing Structure |
|  | Proposed Structure |
|  | Water Supply Well |

BENCHMARK INFORMATION:

TBM: Nail in Utility Pole on North Side of Property.

Approximate Geodetic Elevation =

REFERENCE:

Base Plan and Topographic Information obtained from Topographic Plan No. 22958-22 Pt Lt 12C3 HU T F, dated June, 2022, by Annis O'Sullivan, Vollebakk Ltd.

Additional Base Plan information obtained from
Site Plan No. A012, dated

Consultant



9 AURIGA DRIVE
OTTAWA, ON
K2E 7S9
TEL: (613) 226-7381

07/10/25	Issued for Final review	2
02/10/25	Issued for Client review	1
30/09/25	Issued for Preliminary Discussion Purposes	0
DD/MM/YY	Description	Rev.

Client:

MEGHA HOLDINGS INC.

Project

PROPOSED WAREHOUSE BUILDING
3113 CARP ROAD
OTTAWA (CARP), ONTARIO

Drawing:

SEWAGE SYSTEM LAYOUT PLAN

Scale:

Drawn by:

Date:

	Checked by
--	------------

Drawing no.:

PH5068-1 (rev.2)